

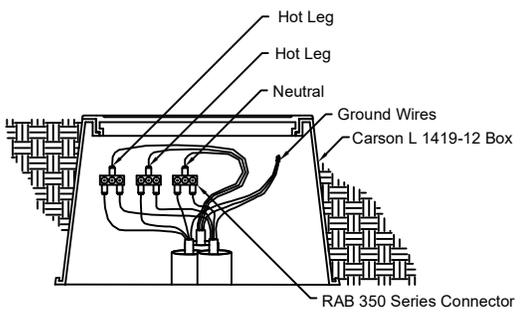


Notes:


- 1) Arterial Light Poles Shall be Located as Indicated on the Approved Lighting Site Plan; and as Described in the City Standards.
- 2) Each Arterial Light Shall Have a Junction Box With Safety Switch and Fuse.
- 3) Fuse Hot Wire in Junction Boxes; Supply Splice Kit for Neutral Wire.
- 4) Mark Junction Box Covers with "Lighting".
- 5) Install PVC Conduits with 24" Cover and Sand Bedding
- 6) Contractor to Install Junction Box with Fuse. Box to be Located 8 Feet From Rocky Mountain Power Transformer or Secondary Box. Leave Pigtail 8 Feet Long to Secondary Box; Rocky Mountain Power to Make Connection.
- 7) 3000 PSI Concrete @ 28 days Per APWA Section 03304
- 8) No Excavation Within 8' of Pole Foundation
- 9) Refer to Millcreek City Vendor for Ordering Light Assembly Parts.
- 10) Rebar and Trench Must be Inspected.
- 11) Electronic Asbuilts must be Sent as Autocad DWG.

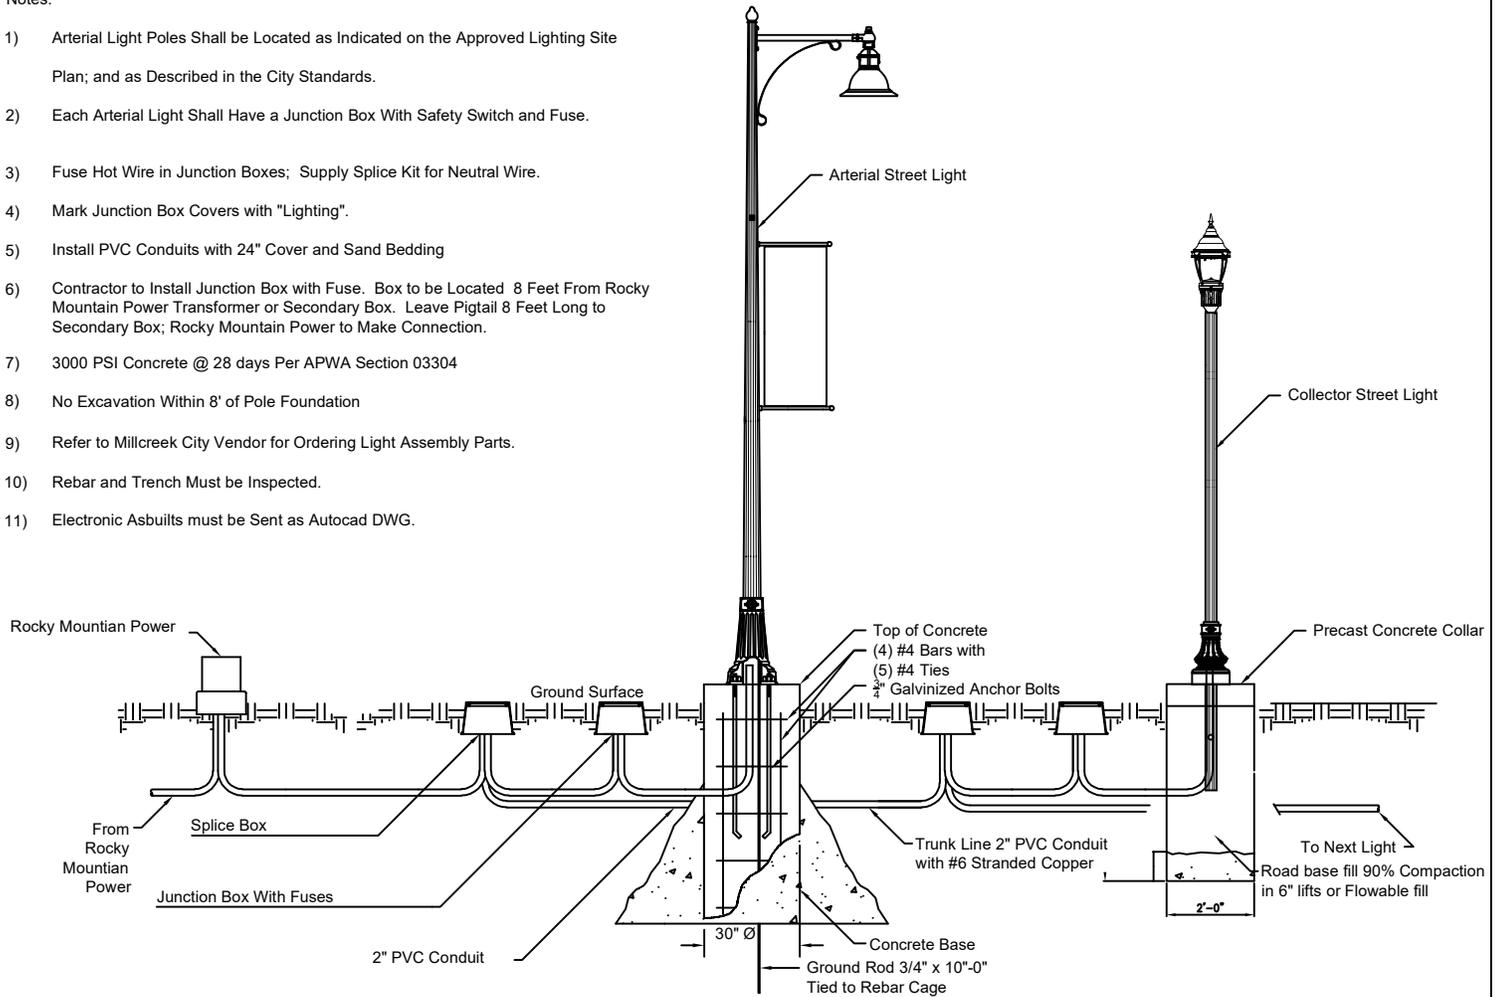

Detail - Splice Box  
Scale: No Scale

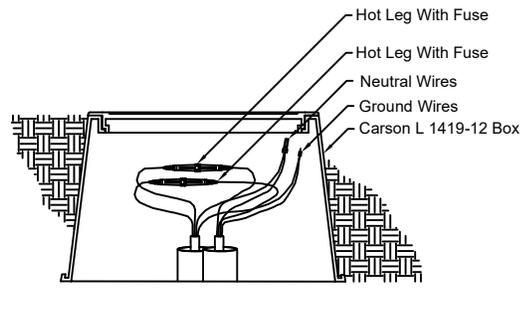

Detail - Junction Box With Fuses  
Scale: No Scale

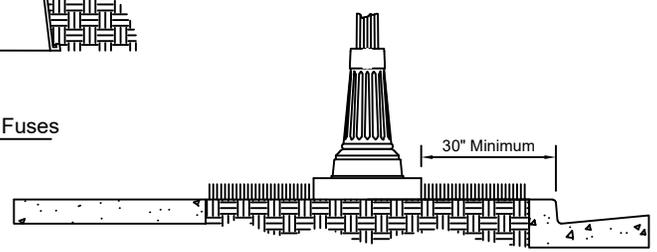

Detail - Pole Spacing From Face of Curb  
Scale: No Scale



  
**Mountain States Lighting**  
 609 Krista Court  
 Murray, Utah 84123  
 Phone 801-268-4879  
 Fax 801-605-9058

**Millcreek City  
Arterial/Collector Underground Details**

SCALE: <b>NTS</b>	DATE: <b>10/21/19</b>	DRAWN BY: <b>FTM</b>	DRAWING NUMBER: <b>MIL-SL-05</b>
----------------------	--------------------------	-------------------------	-------------------------------------

MILLCREEK CITY APPROVAL: